

EAST ELEVATION SCALE: 1 : 100



NORTH ELEVATION SCALE: 1 : 100


83100		L25 FFL +83025
		L18 FFL +81200
		05-FOURTH FLOOR 1.0 FFL +78050
		04-THIRD FLOOR 1.0 FFL +74900
		03-SECOND 1.0 FFL +71750
		02-FIRST 1.0 FFL +68600
		01-GROUND 1.0 FFL +64850

GENERAL NOTES DO NOT SCALE FROM DRAWINGS. WORK TO FIGURED DIMENSIONS ONLY. ARCHITECT TO BE NOTIFIED OF ANY DISCREPANCIES.

THIS DRAWING TO BE READ IN CONJUNCTION WITH ALL ARCHITECT'S DRAWINGS, SPECIFICATIONS CONSULTANT'S DESIGN TEAM DRAWINGS AND SPECIFICATIONS.

NOTES:

- PLEASE REFER TO MALONE O'REGAN CONSULTING ENGINEERS FOR ALL STRUCTURAL DRAWINGS AND DETAILS
- PLEASE REFER TO SEMPLE MCKILLOP CONSULTING ENGINEERS DRAWINGS FOR ALL MECHANICAL & ELECTRICAL DETAIL FOR THE FOLLOWING:
- All proposed Mechanical Ventilation details
 AOV's min clear opening 1,5m² to specialist details
 SVP drop locations & details
 Electrical layout & Lift Services specification
 Fire detection system specification & details throughout
 Escape lighting specification & details & exit signage
- IMPORTANT NOTE: PLEASE REFER TO MITCHEL+ ASSOCIATES DRAWINGS/ REPORT FOR LANDSCAPING DETAILS
- MATERIALS AND FINISHES:
- 1- LIGHT BUFF BRICK 2- CONTRASTING DARK BRICK 3- METAL BALCONY-COLOUR TO MATCH METAL GOODS 4- METAL GATE-COLOUR TO MATCH METAL GOODS 5-WHITE RENDER

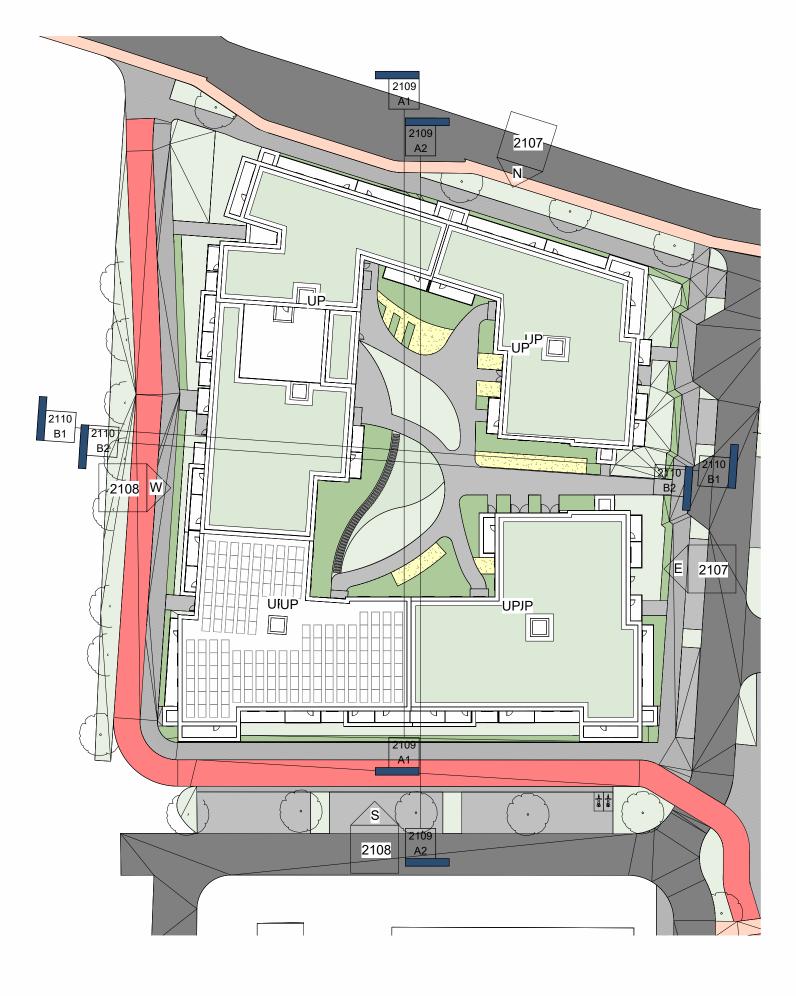

0R .5	
.5	
.5 00	

REV	DATE	DESCRIPTION	Issued by
REV	ISIONS		

FOR PLANNING

CLIENT: NDFA On behalf of Dublin City Council PROJECT TITLE
SHB 5 BMD, Ballymun, Dublin 11

DRAWING TITLE: SITE 18- ELEVATIONS SHEET 01

