

SECTION B1-B1 SCALE: 1 : 100




GENERAL NOTES DO NOT SCALE FROM DRAWINGS. WORK TO FIGURED DIMENSIONS ONLY. ARCHITECT TO BE NOTIFIED OF ANY DISCREPANCIES.

THIS DRAWING TO BE READ IN CONJUNCTION WITH ALL ARCHITECT'S DRAWINGS, SPECIFICATIONS CONSULTANT'S DESIGN TEAM DRAWINGS AND SPECIFICATIONS.

NOTES:

- PLEASE REFER TO MALONE O'REGAN CONSULTING ENGINEERS FOR ALL STRUCTURAL DRAWINGS AND DETAILS
- PLEASE REFER TO SEMPLE MCKILLOP CONSULTING ENGINEERS DRAWINGS FOR ALL MECHANICAL & ELECTRICAL DETAIL FOR THE FOLLOWING:
- All proposed Mechanical Ventilation details
 AOV's min clear opening 1,5m² to specialist details
 SVP drop locations & details
 Electrical layout & Lift Services specification
 Fire detection system specification & details throughout
 Escape lighting specification & details & exit signage
- IMPORTANT NOTE: PLEASE REFER TO MITCHEL+ ASSOCIATES DRAWINGS/ REPORT FOR LANDSCAPING DETAILS
- MATERIALS AND FINISHES:
- 1- LIGHT BUFF BRICK 2- CONTRASTING DARK BRICK 3- METAL BALCONY-COLOUR TO MATCH METAL GOODS 4- METAL GATE-COLOUR TO MATCH METAL GOODS 5-WHITE RENDER

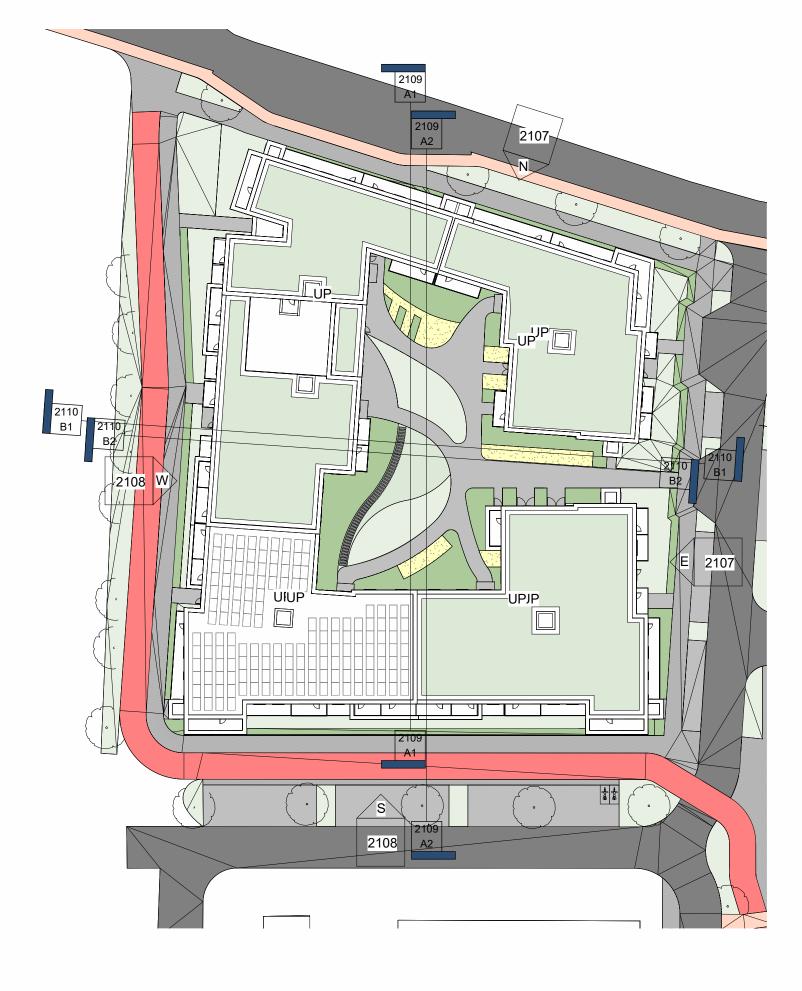


REV	DATE	DESCRIPTION	Issued by
REVI	ISIONS		

FOR PLANNING

NDFA On behalf of Dublin City Council PROJECT TITLE
SHB 5 BMD, Ballymun, Dublin 11

DRAWING TITLE: SITE 18- ELEVATIONS/ SECTIONS

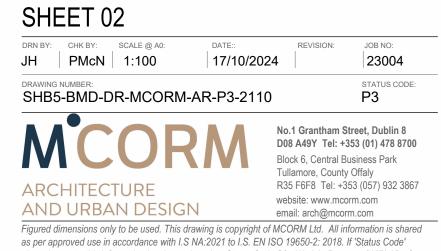

above is empty, this information has been shared as Status Code S0 - Work in Progress (WIP) / Draft.